



Addendum #2

Project: 20250274 - IN083 CAMPUS CENTER - REPLACE BUILDING LIGHTING CONTROLS

Date: February 12, 2026

This Addendum, issued prior to bidding, alters, amends, corrects, or clarifies the Construction Bid Documents to the extent stated herein and does thereby become a part of the Construction Bid Documents, and will become part of the Contract Documents of the successful bidder. Acknowledge receipt of this Addendum in the space provided on the Bid Form. Failure to do so may subject the Bidder to disqualification.

ITEMS INCLUDED IN THIS ADDENDUM

1. As a general note to all drawings: All lighting control devices and equipment to be replaced shall be turned over to the IUI Building Manager.
2. Contractor is to test and confirm the control wiring to the system devices and replace if found faulty or damaged. An allowance of \$600.00 shall be utilized for replacement of any wiring shown on plans to be re-used. Otherwise, control wiring is planned to be re-used to existing device locations.
3. For clarification, existing dimming racks and relay panels are to be refurbished, cleaned, and made ready for updated lighting control equipment. Contractor scope is to de-energize the cabinets and make safe for ETC to perform the work.
4. The upgraded system is planned to be web-based for users. An interface to campus network is necessary. Contractor is to include pricing to arrange a pathway from headend equipment in room 274 to the nearest IDF. Pathway can be conduit, cable tray, or j-hooks. All other work to be by UITS.

Attachments

1. Original drawing E0A Theater Level Lighting Riser to be superseded by CLI Theater Level Sheet 1 of 6.
2. Original drawing E1A First Level Lighting Riser to be superseded by CLI First Level Sheet 2 of 6.
3. Original drawing E2A Second Level Lighting Riser to be superseded by CLI Second Level Sheet 3 of 6.

4. Original drawing E3A Third Level Lighting Riser to be superseded by CLI Third Level Sheet 4 of 6.
5. Original drawing E4A Fourth Level Lighting Riser to be superseded by CLI Fourth Level Sheet 5 of 6.
6. Original drawing E5A Fifth Level Lighting Riser to be superseded by CLI Fifth Level Sheet 6 of 6.


END OF ADDENDUM 2

Control wiring legend

| Symbol | Wire type(s) | Signal |
|--------|------------------------------|-------------|
| N | (1) BELDEN 1583A | NETWORK |
| U | (1) TMB PCLP1PT (NON-PLENUM) | LINKCONNECT |
| A | (2) #16 AWG.STRANDED WIRES | AUXILIARY |

Approved Wire Type Alternates can be found here:

<https://www.etcconnect.com/cablecross>

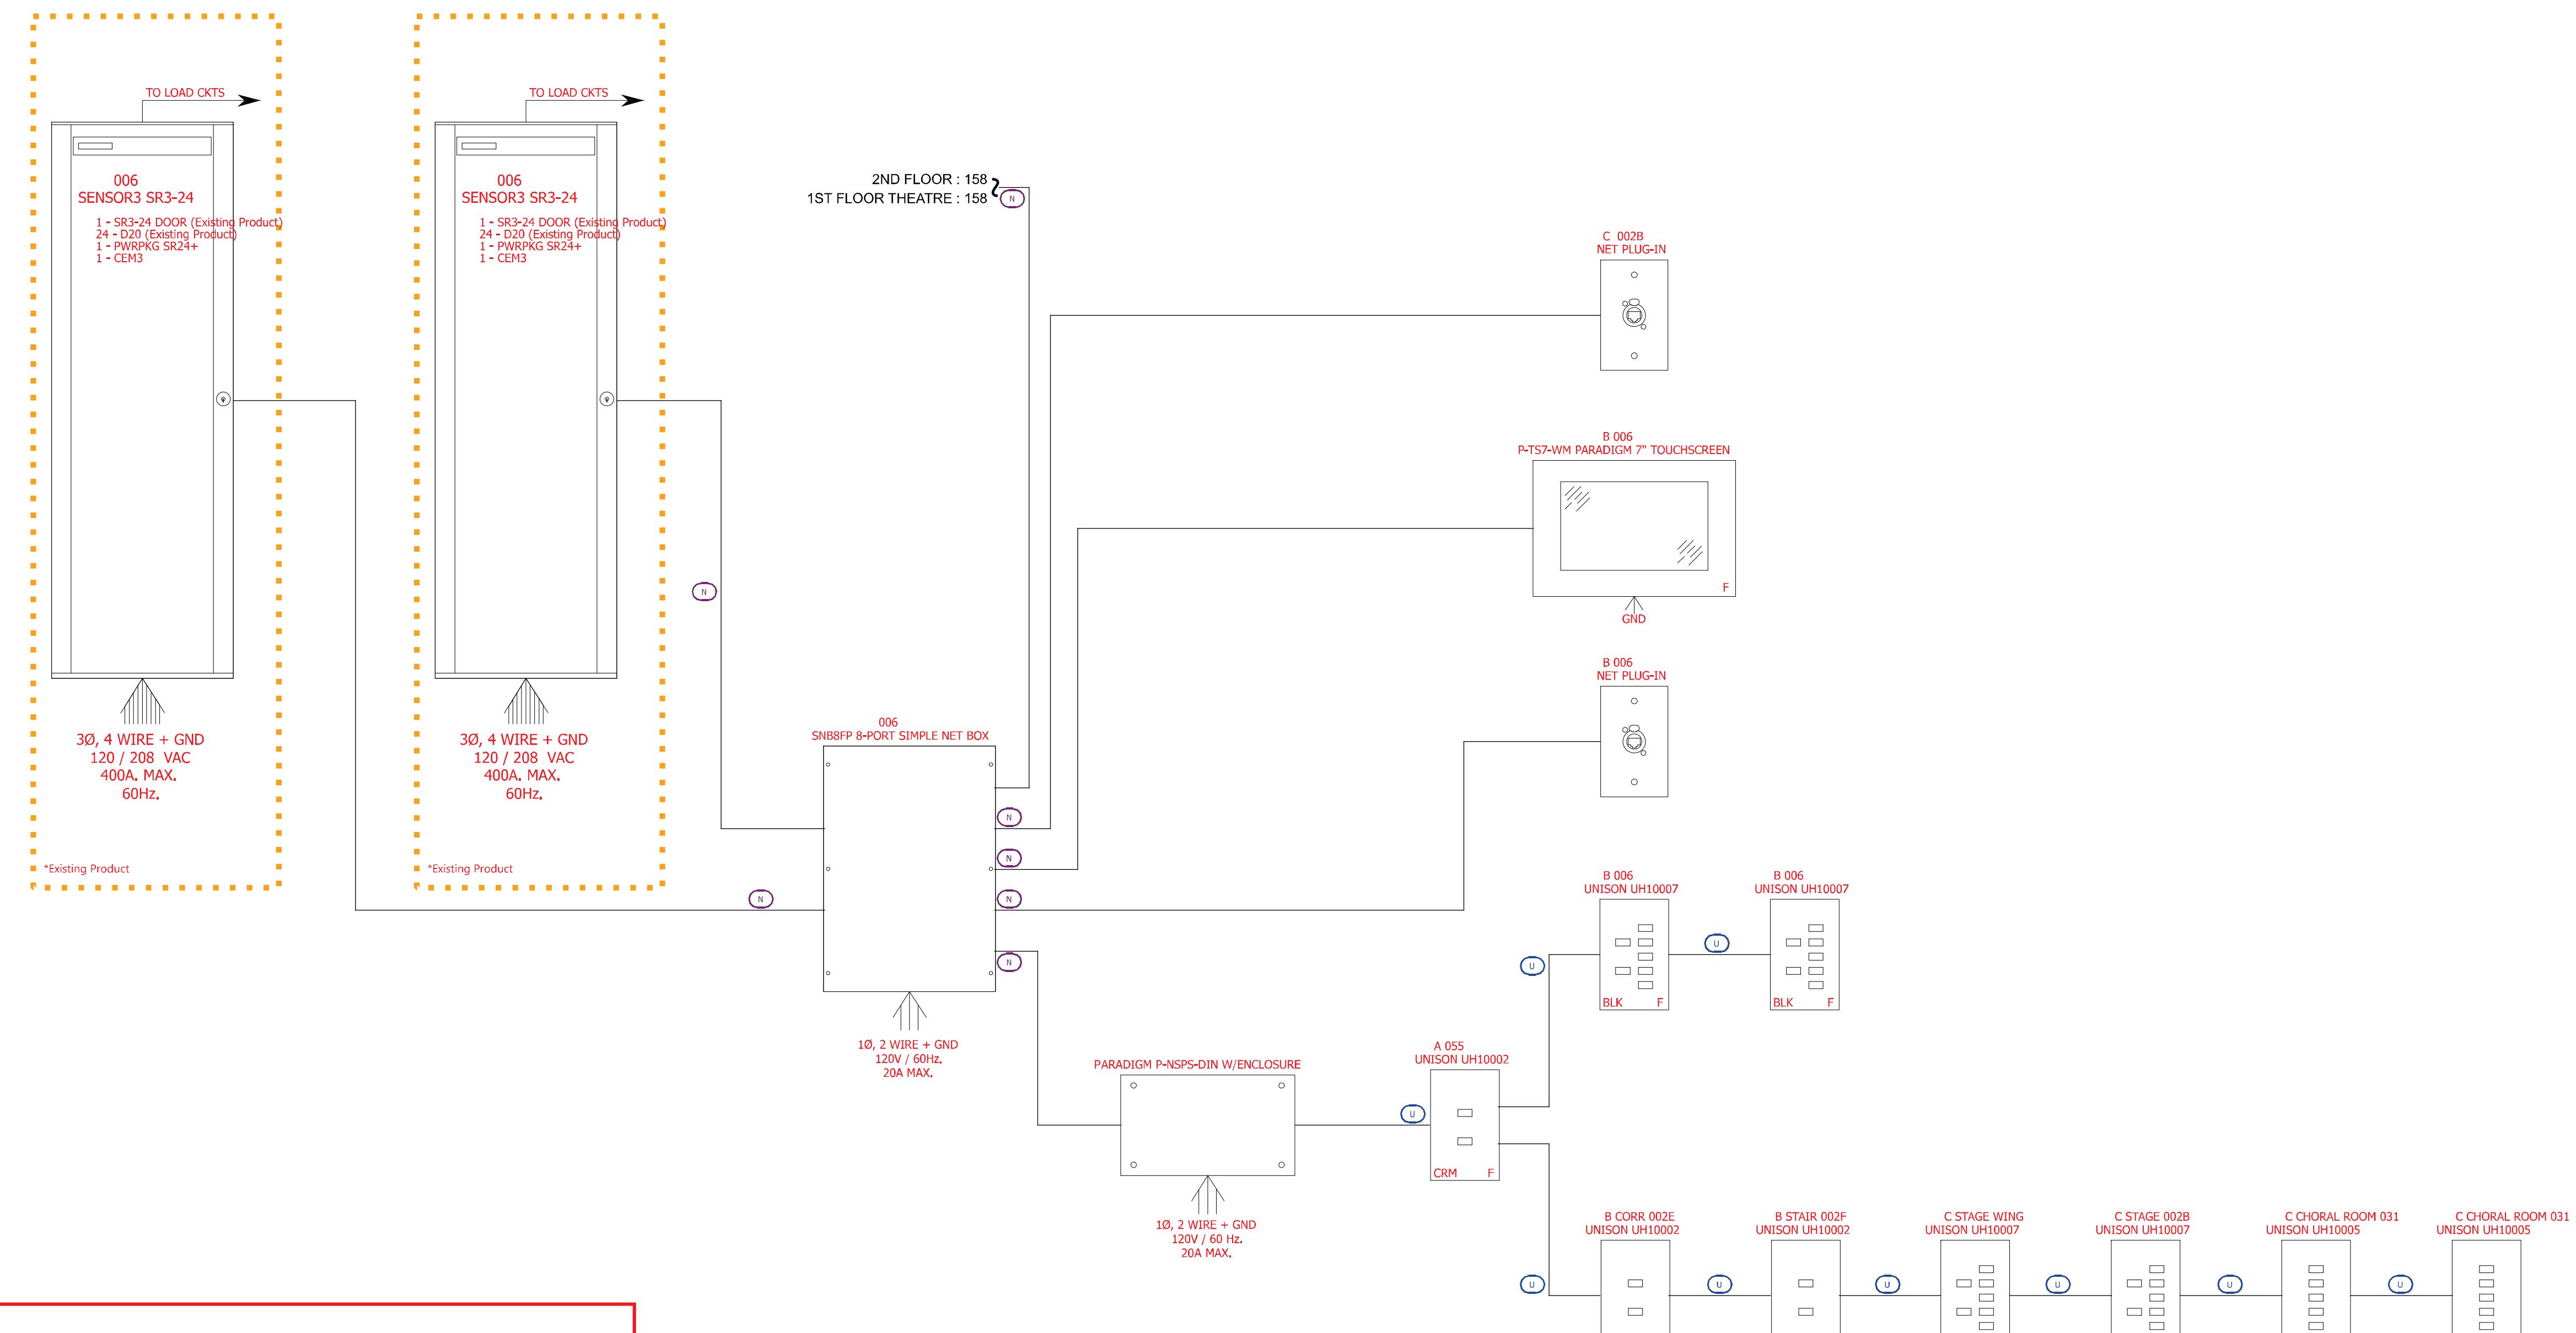

Area: THEATRE



ETC, Inc.

3031 Pleasant View Rd.
PO Box 620979
Middleton WI 53562-0979
Toll Free +1 800 688 4116
etcconnect.com

REPRESENTATIVE:



CLI

REFERENCE DRAWING:

PREPARED FOR:

PREPARED BY:

PROJECT MANAGER:

| | | |
|-----|---------|------|
| sam | 2/12/26 | #2 |
| rjd | 1/21/26 | #1 |
| | | |
| | | |
| | 2/6/25 | |
| BY | DATE | REV. |

PROJECT NAME:

IU CAMPUS CENTER
UPGRADES

PROJECT LOCATION:
INDIANAPOLIS, Indiana, USA,
46202

PROJECT NUMBER:

SHEET TITLE:
Theatre


SHEET NUMBER:
1 of 6

Control wiring legend

| Symbol | Wire type(s) | Signal |
|--------|------------------------------|-------------|
| | (1) BELDEN 1583A | NETWORK |
| | (1) TMB PCLP1PT (NON-PLENUM) | LINKCONNECT |
| | (2) #16 AWG.STRANDED WIRES | AUXILIARY |

Approved Wire Type Alternates can be found here:

<https://www.etcconnect.com/cablecross>

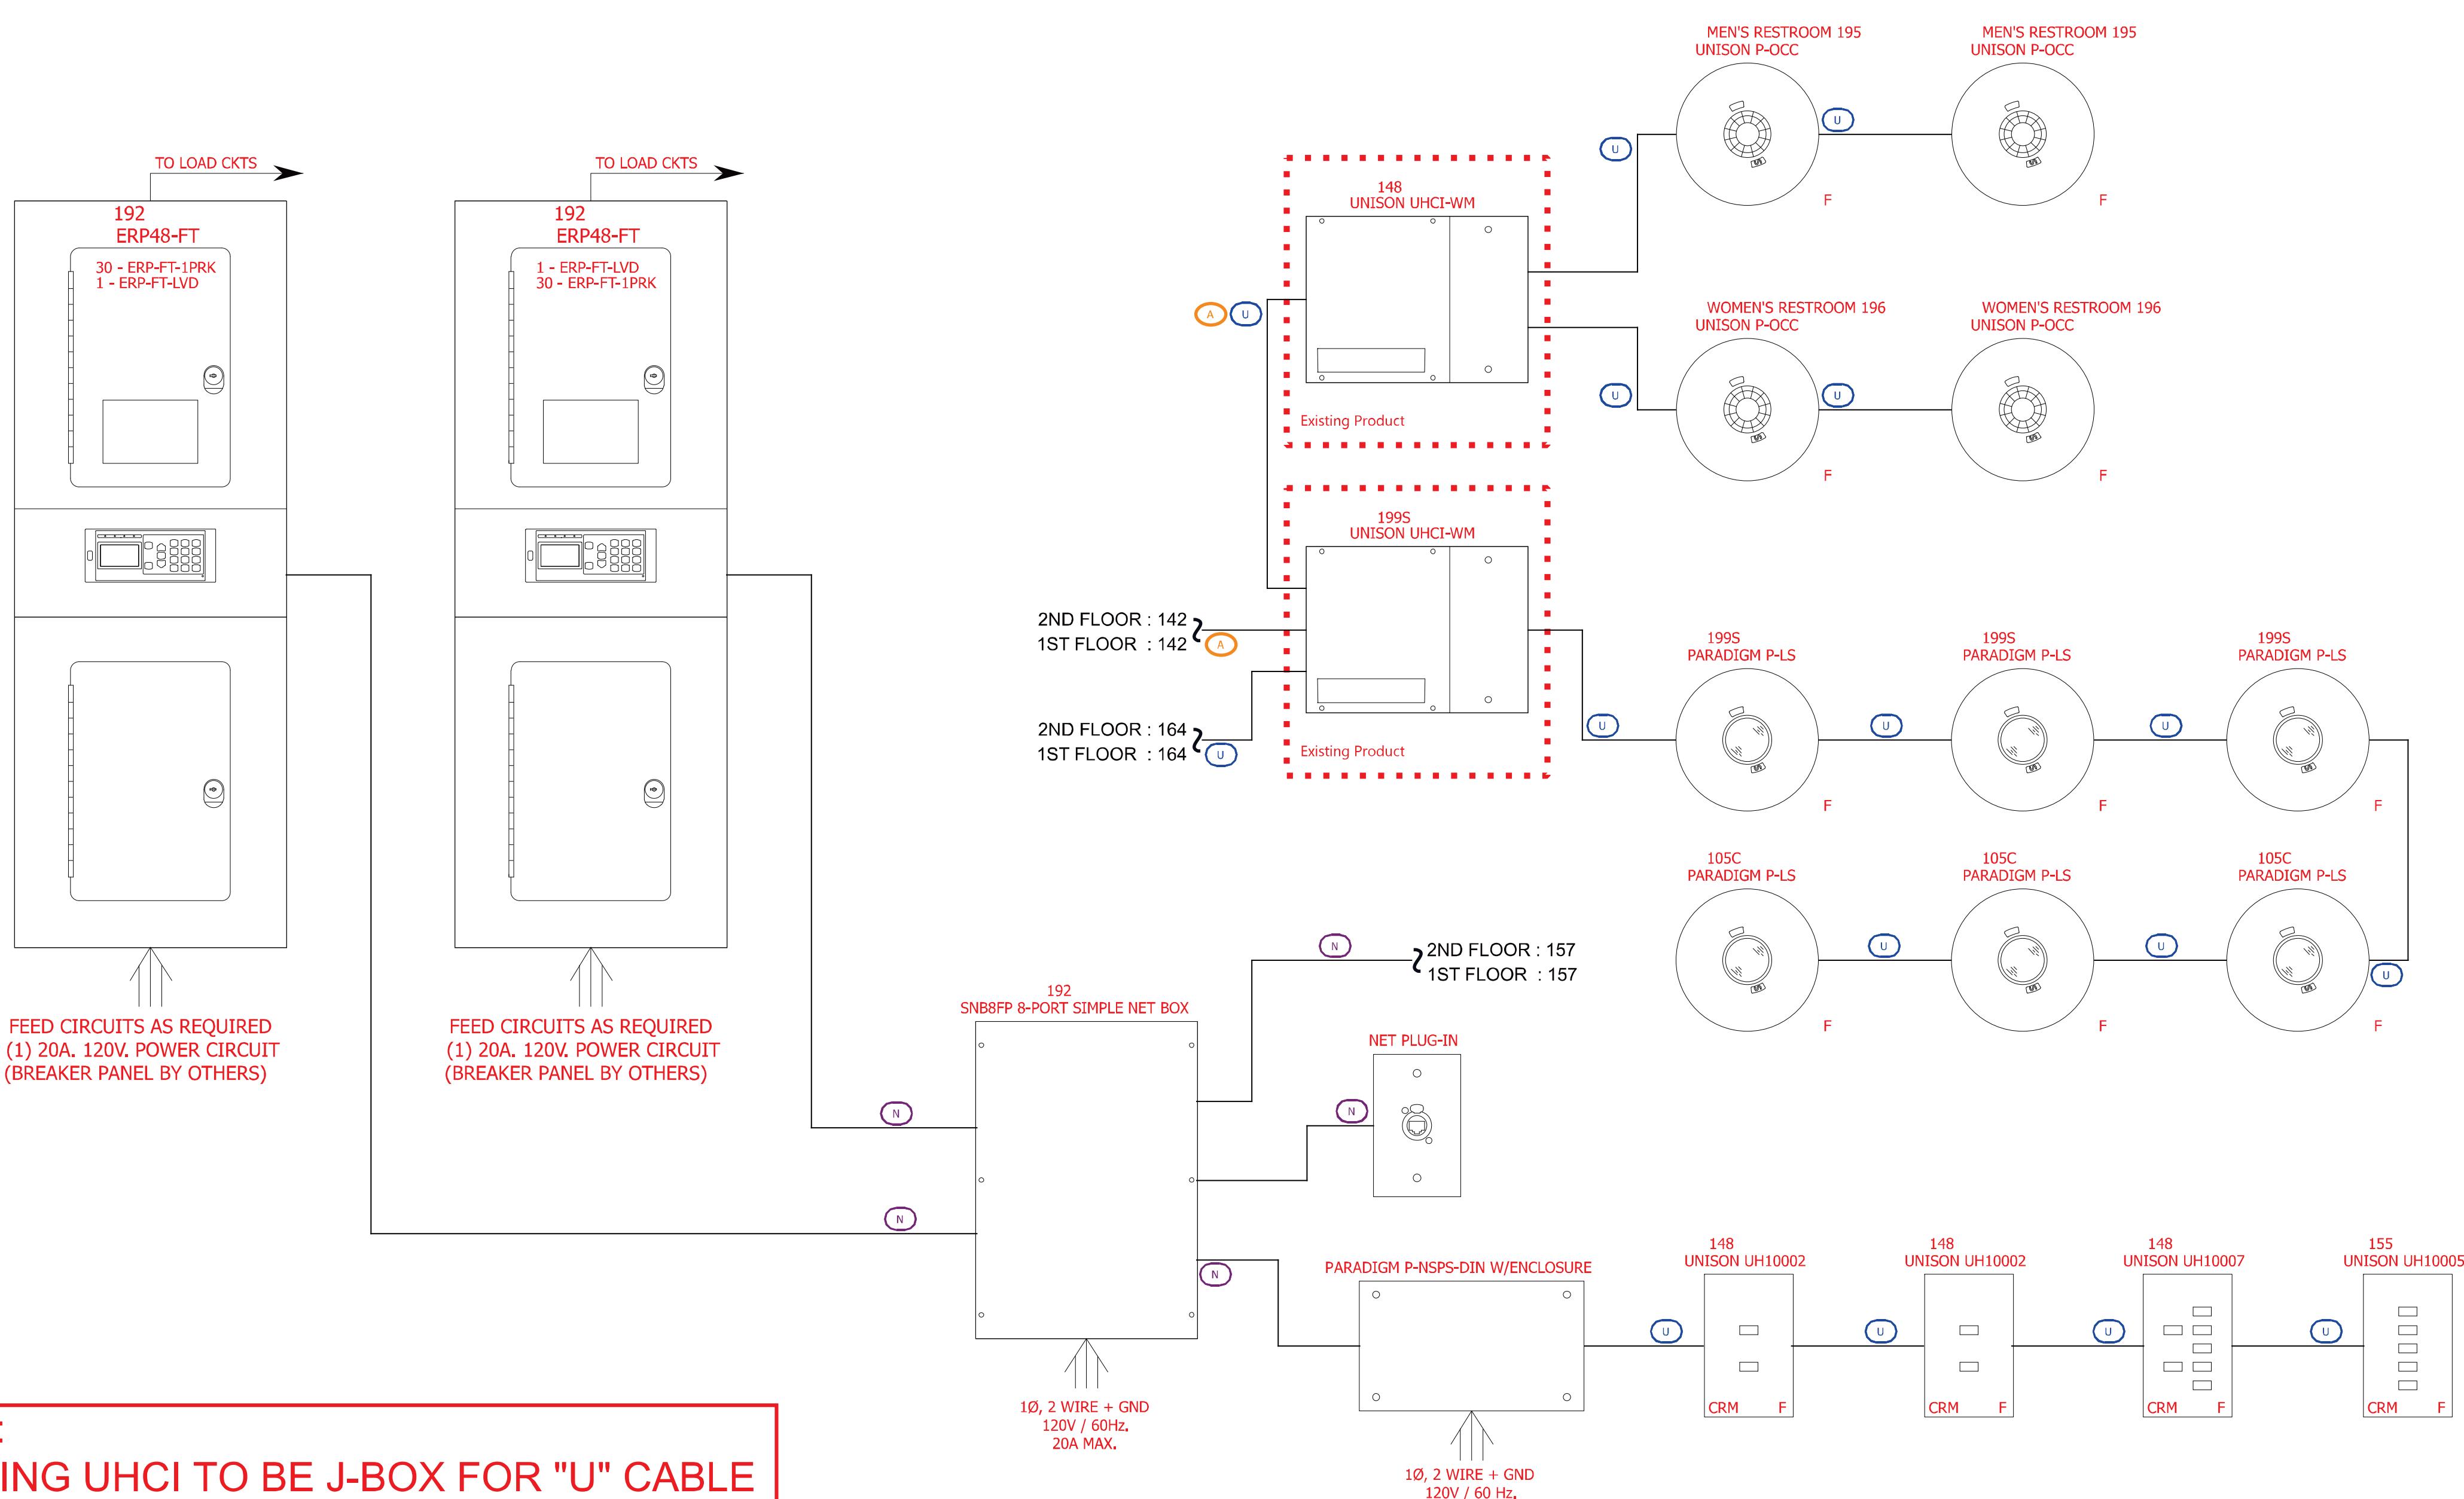

Area: 1ST FLOOR



ETC, Inc.

3031 Pleasant View Rd.
PO Box 620979
Middleton WI 53562-0979
Toll Free + 1 800 688 4116
etcconnect.com

REPRESENTATIVE:



CLI

REFERENCE DRAWING:

PREPARED FOR:

PREPARED BY:

PROJECT MANAGER:

| | | |
|-----|---------|------|
| sam | 2/12/26 | #2 |
| rjd | 1/21/26 | #1 |
| | | |
| | | |
| | 2/6/25 | |
| BY | DATE | REV. |

PROJECT NAME:

IU CAMPUS CENTER
UPGRADES

PROJECT LOCATION:
INDIANAPOLIS, Indiana, USA,
46202

PROJECT NUMBER:


SHEET TITLE:
First Floor

SHEET NUMBER:
2 of 6

Control wiring legend

| Symbol | Wire type(s) | Signal |
|--------|------------------------------|-------------|
| N | (1) BELDEN 1583A | NETWORK |
| A | (2) #16 AWG.STRANDED WIRES | AUXILIARY |
| U | (1) TMB PCLP1PT (NON-PLENUM) | LINKCONNECT |
| A | (2) #16 AWG.STRANDED WIRES | AUXILIARY |

Approved Wire Type Alternates can be found here:
<https://www.etcconnect.com/cablecross>

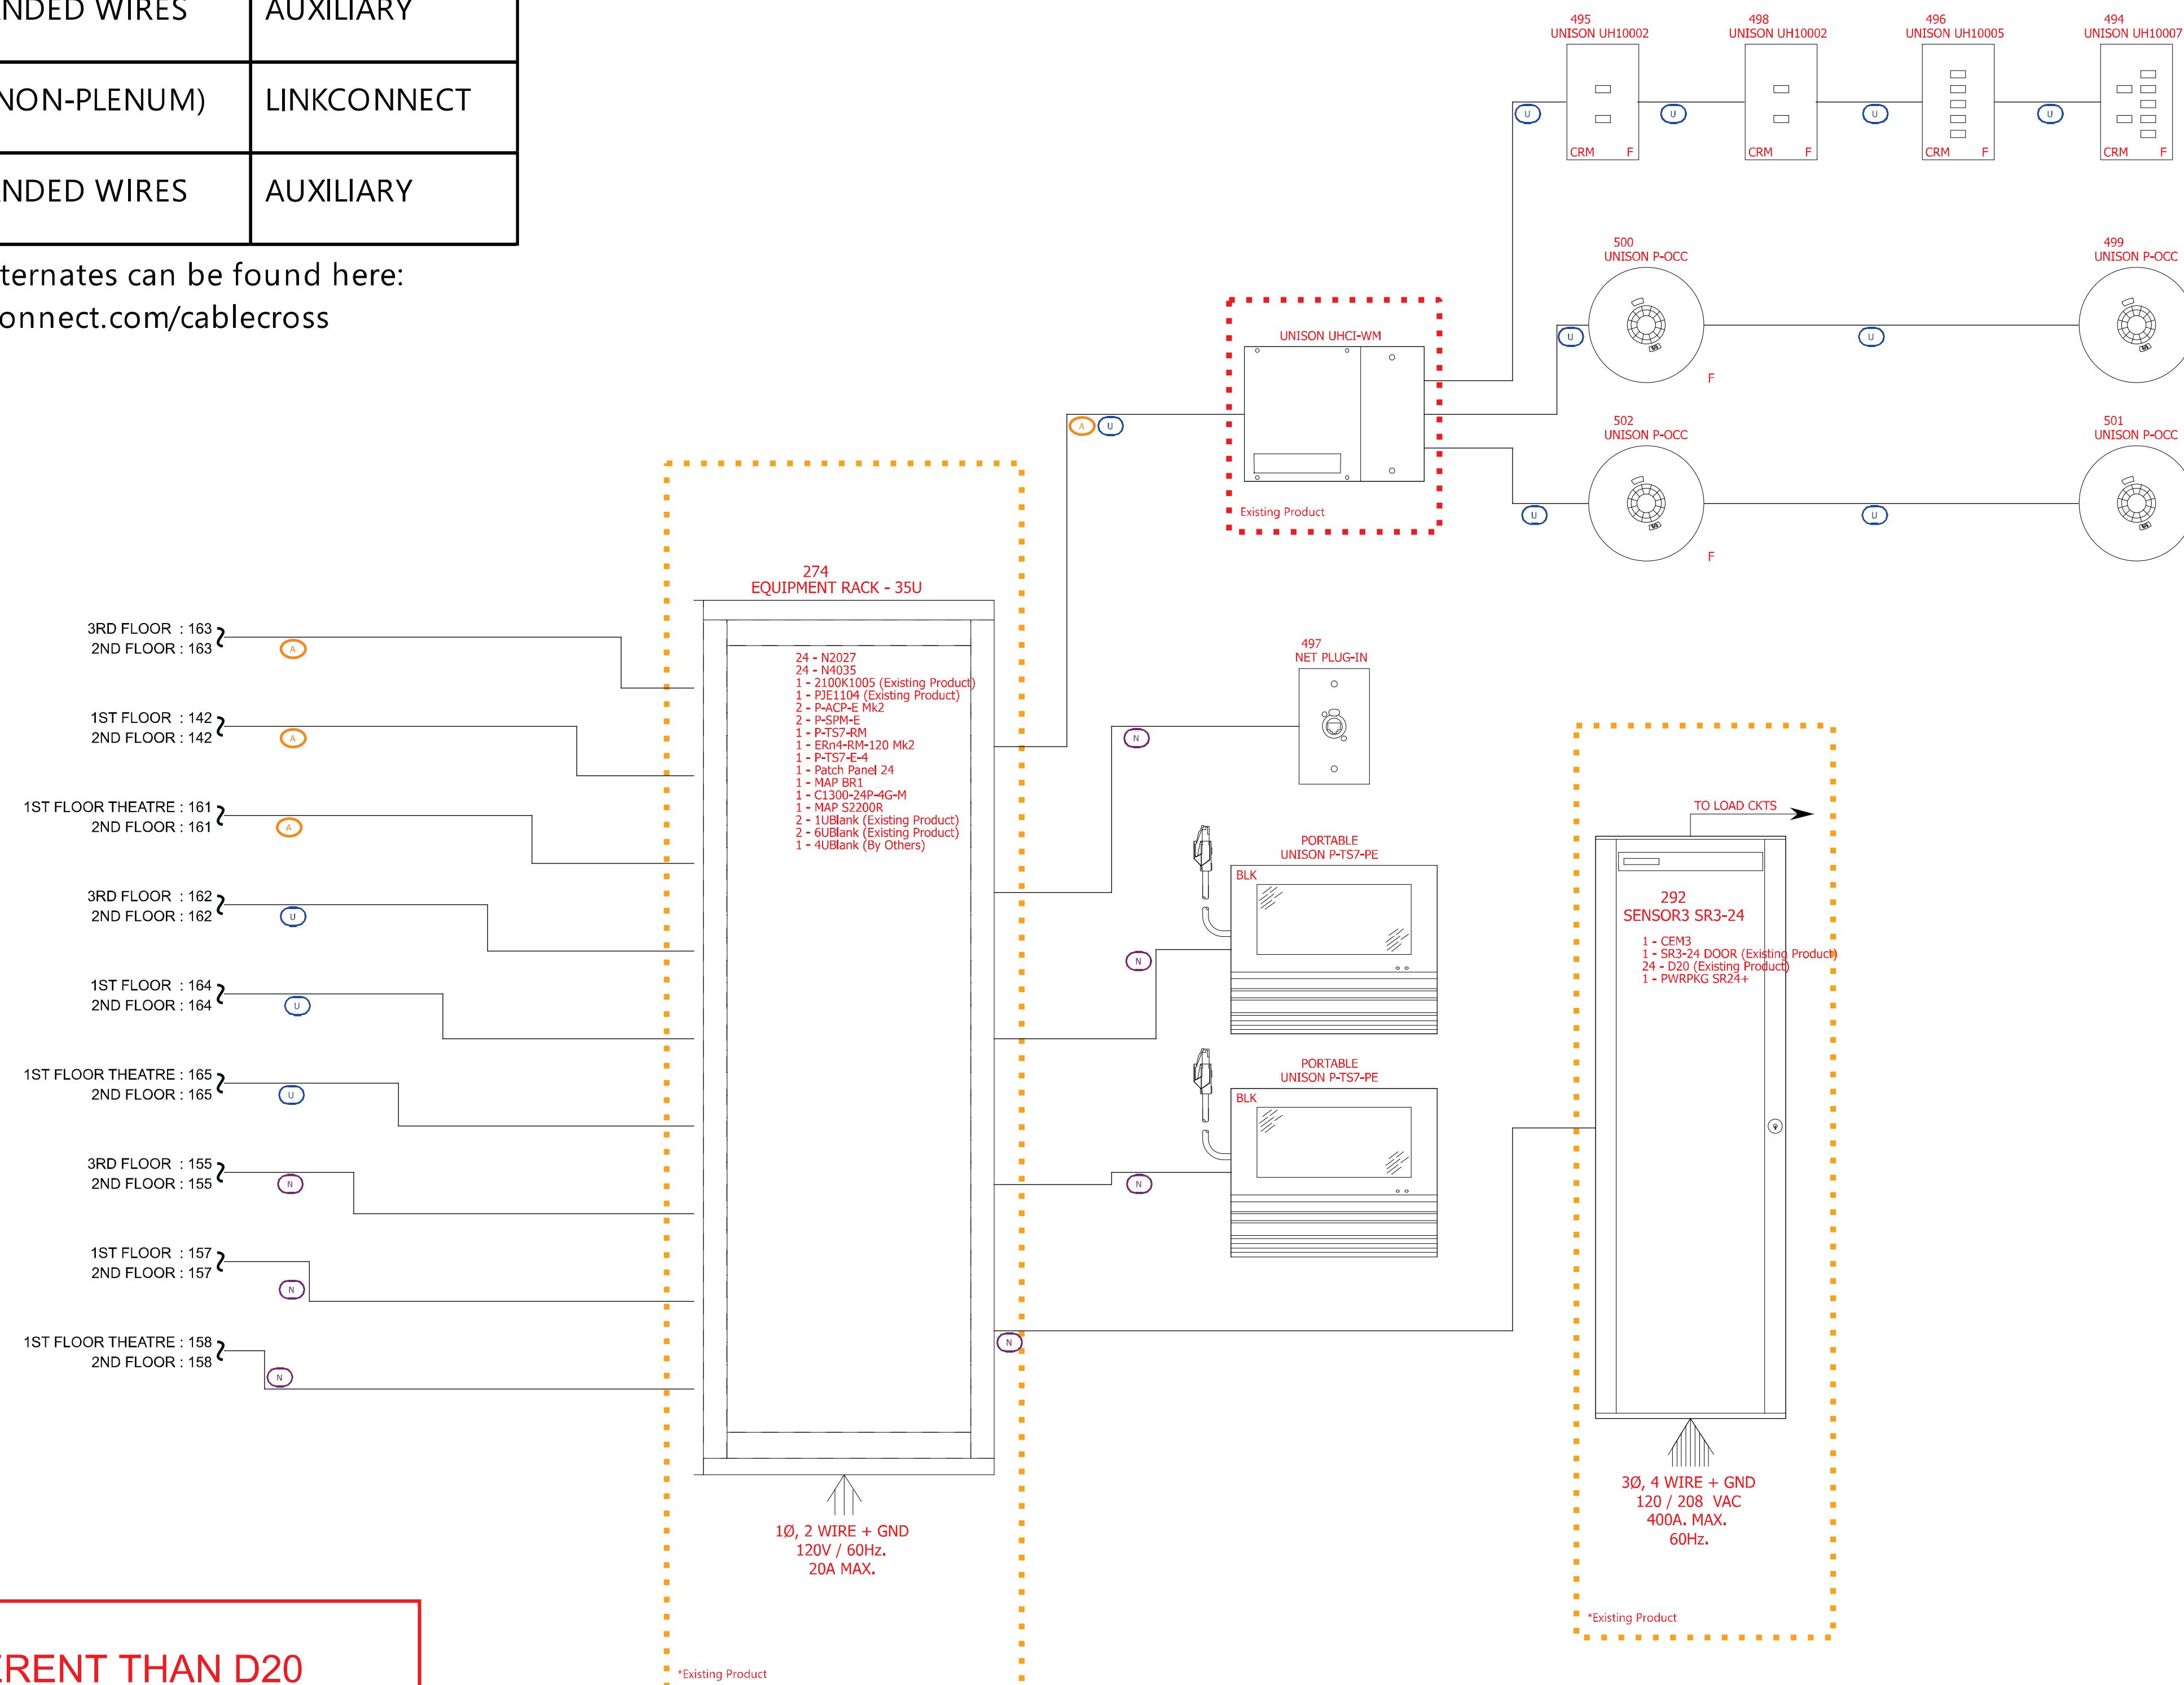

NOTE:
MODULES MAY BE DIFFERENT THAN D20
EXISTING UHCI TO BE J-BOX FOR "U" CABLE

Area: 2ND FLOOR



ETC, Inc.

3031 Pleasant View Rd.
PO Box 620979
Middleton WI 53562-0979
Toll Free + 1 800 688 4116
etcconnect.com

REPRESENTATIVE:



CLI

REFERENCE DRAWING:

PREPARED FOR:

PREPARED BY:

PROJECT MANAGER:

| | | |
|-----|---------|------|
| sam | 2/12/26 | #2 |
| rjd | 1/21/26 | #1 |
| | | |
| | | |
| | 2/6/25 | |
| BY | DATE | REV. |

PROJECT NAME:

IU CAMPUS CENTER
UPGRADES

PROJECT LOCATION:
INDIANAPOLIS, Indiana, USA,
46202

PROJECT NUMBER:

SHEET TITLE:
Second Floor


SHEET NUMBER:
3 of 6

Control wiring legend

| <i>Symbol</i> | <i>Wire type(s)</i> | <i>Signal</i> |
|---|------------------------------|---------------|
|  | (1) TMB PCLP1PT (NON-PLENUM) | LINKCONNECT |
|  | (1) BELDEN 1583A | NETWORK |
|  | (2) #16 AWG.STRANDED WIRES | AUXILIARY |


Approved Wire Type Alternates can be found here:

<https://www.etccconnect.com/cablecross>

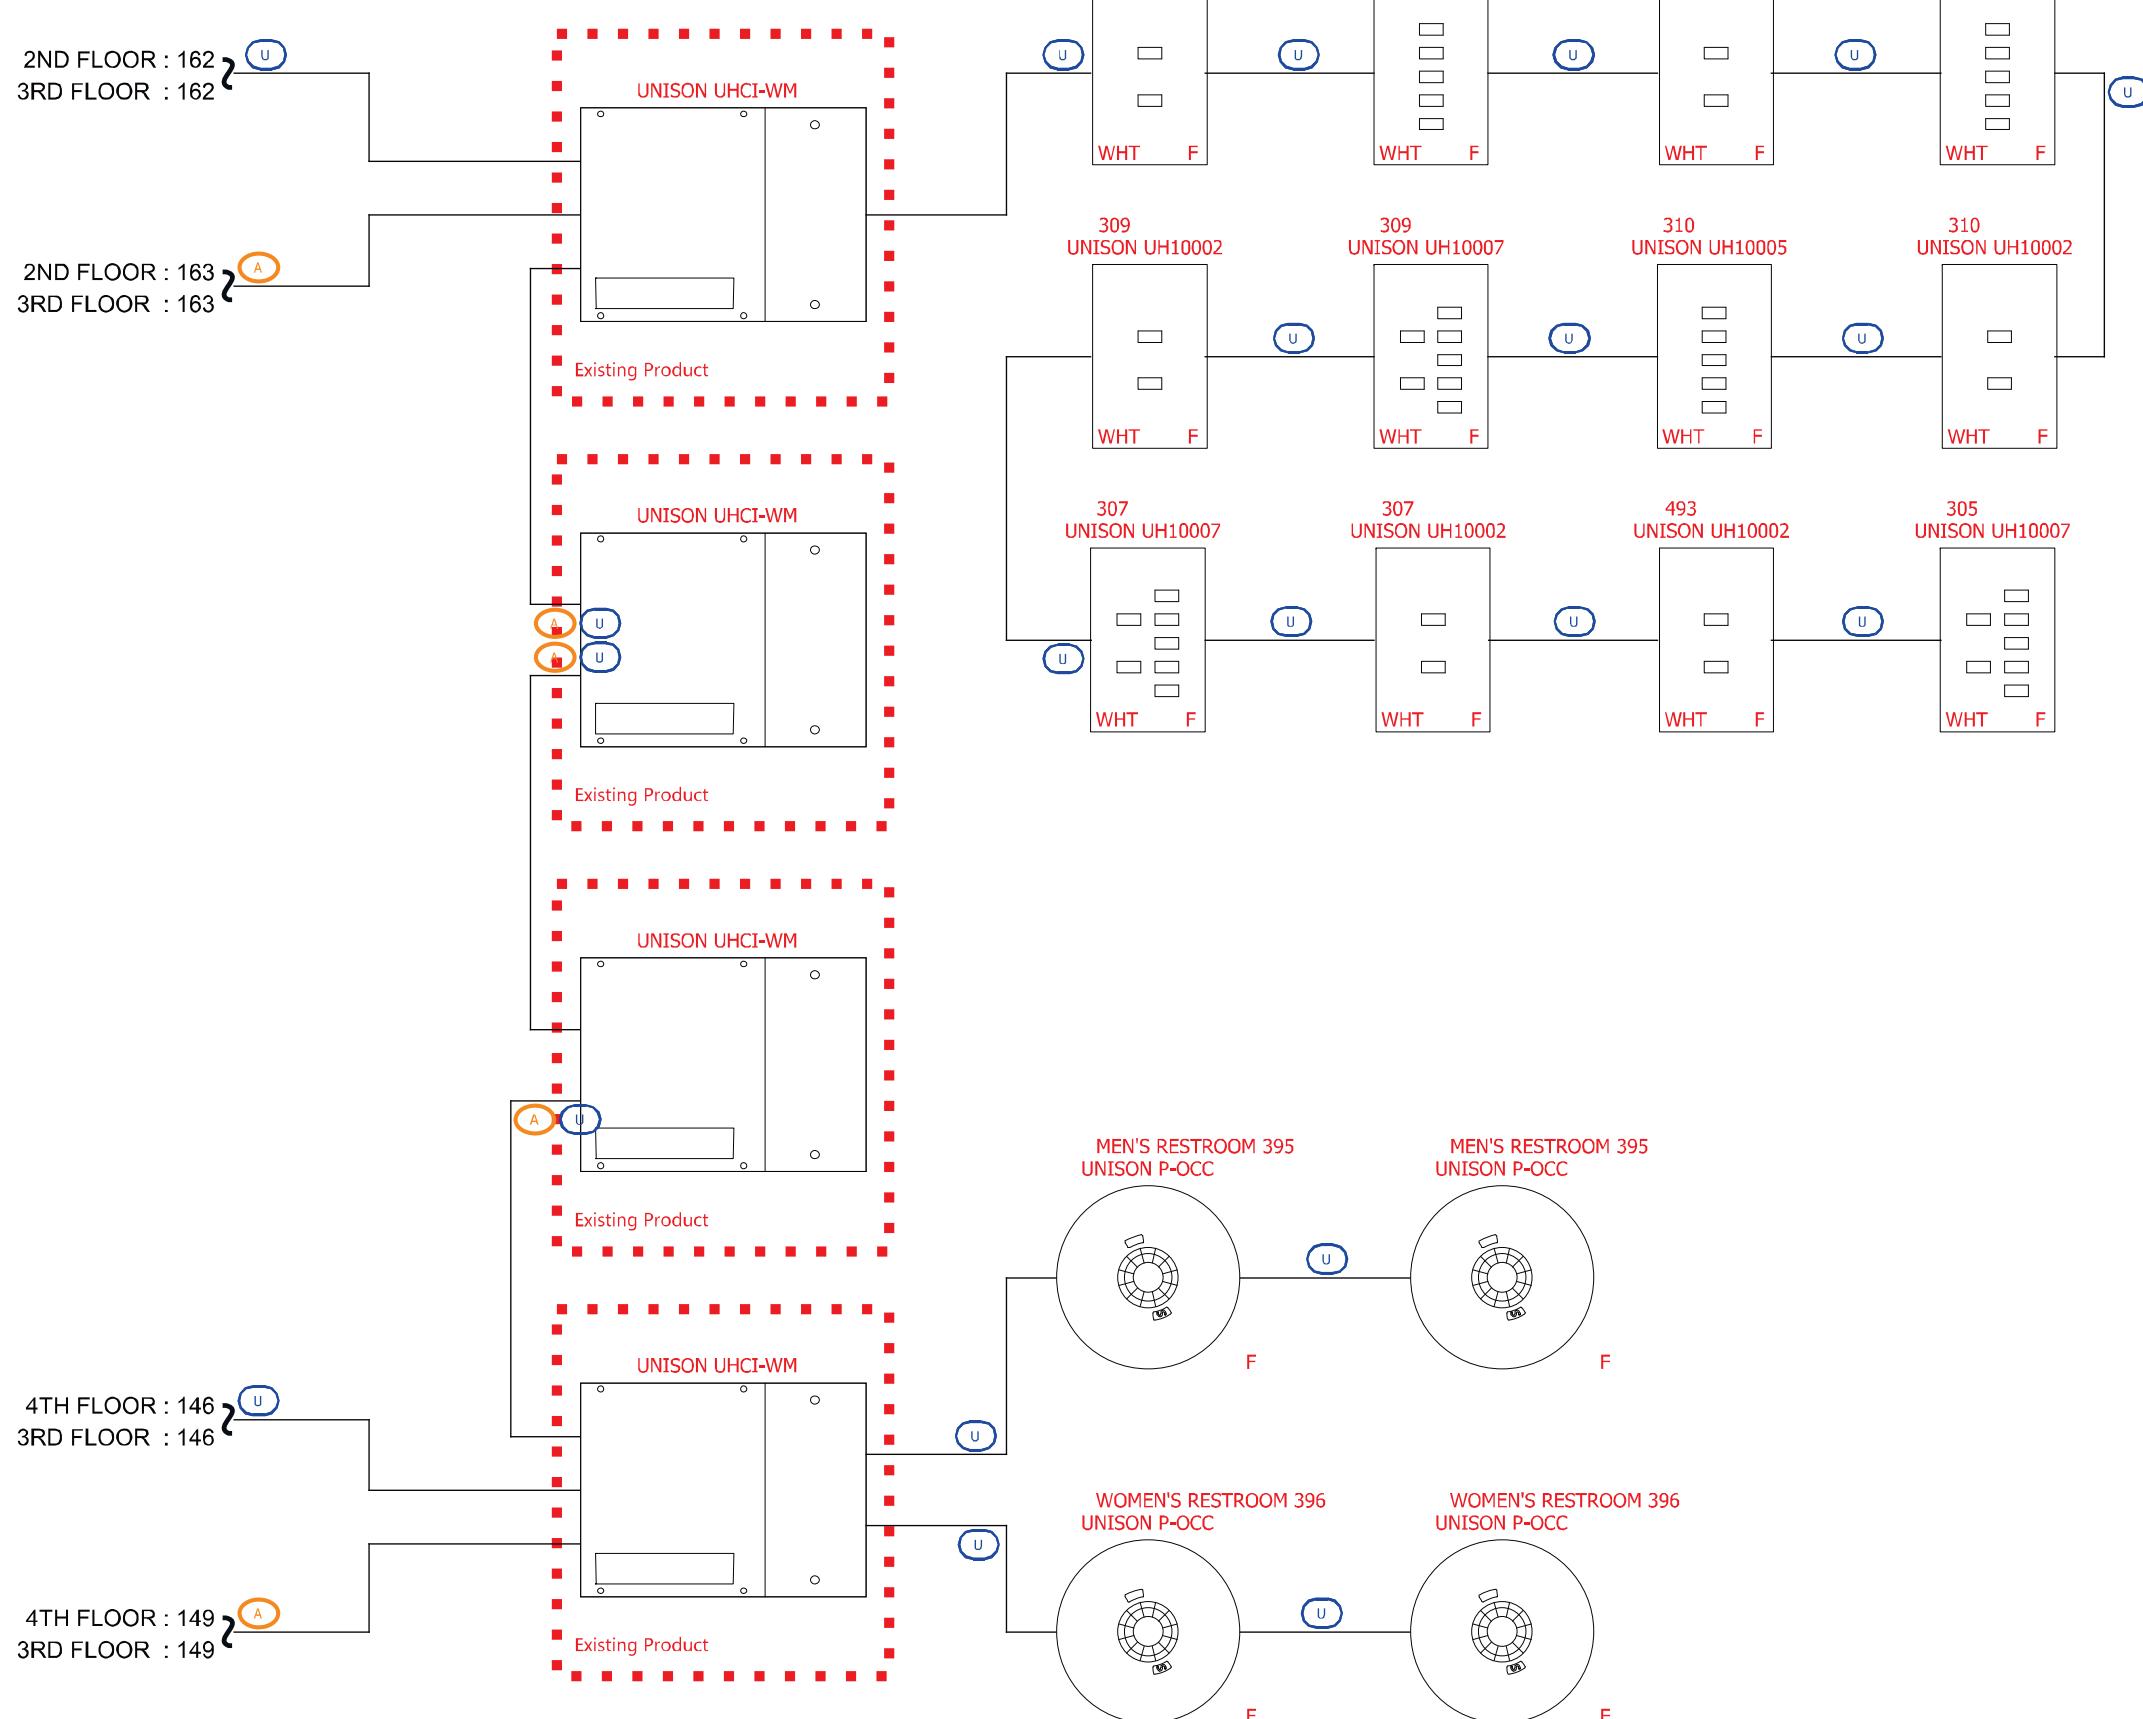

**NOTE:
MODULES MAY BE DIFFERENT THAN D20
EXISTING UHCI TO BE J-BOX FOR "U" CABLE**

Area: 3RD FLOOR

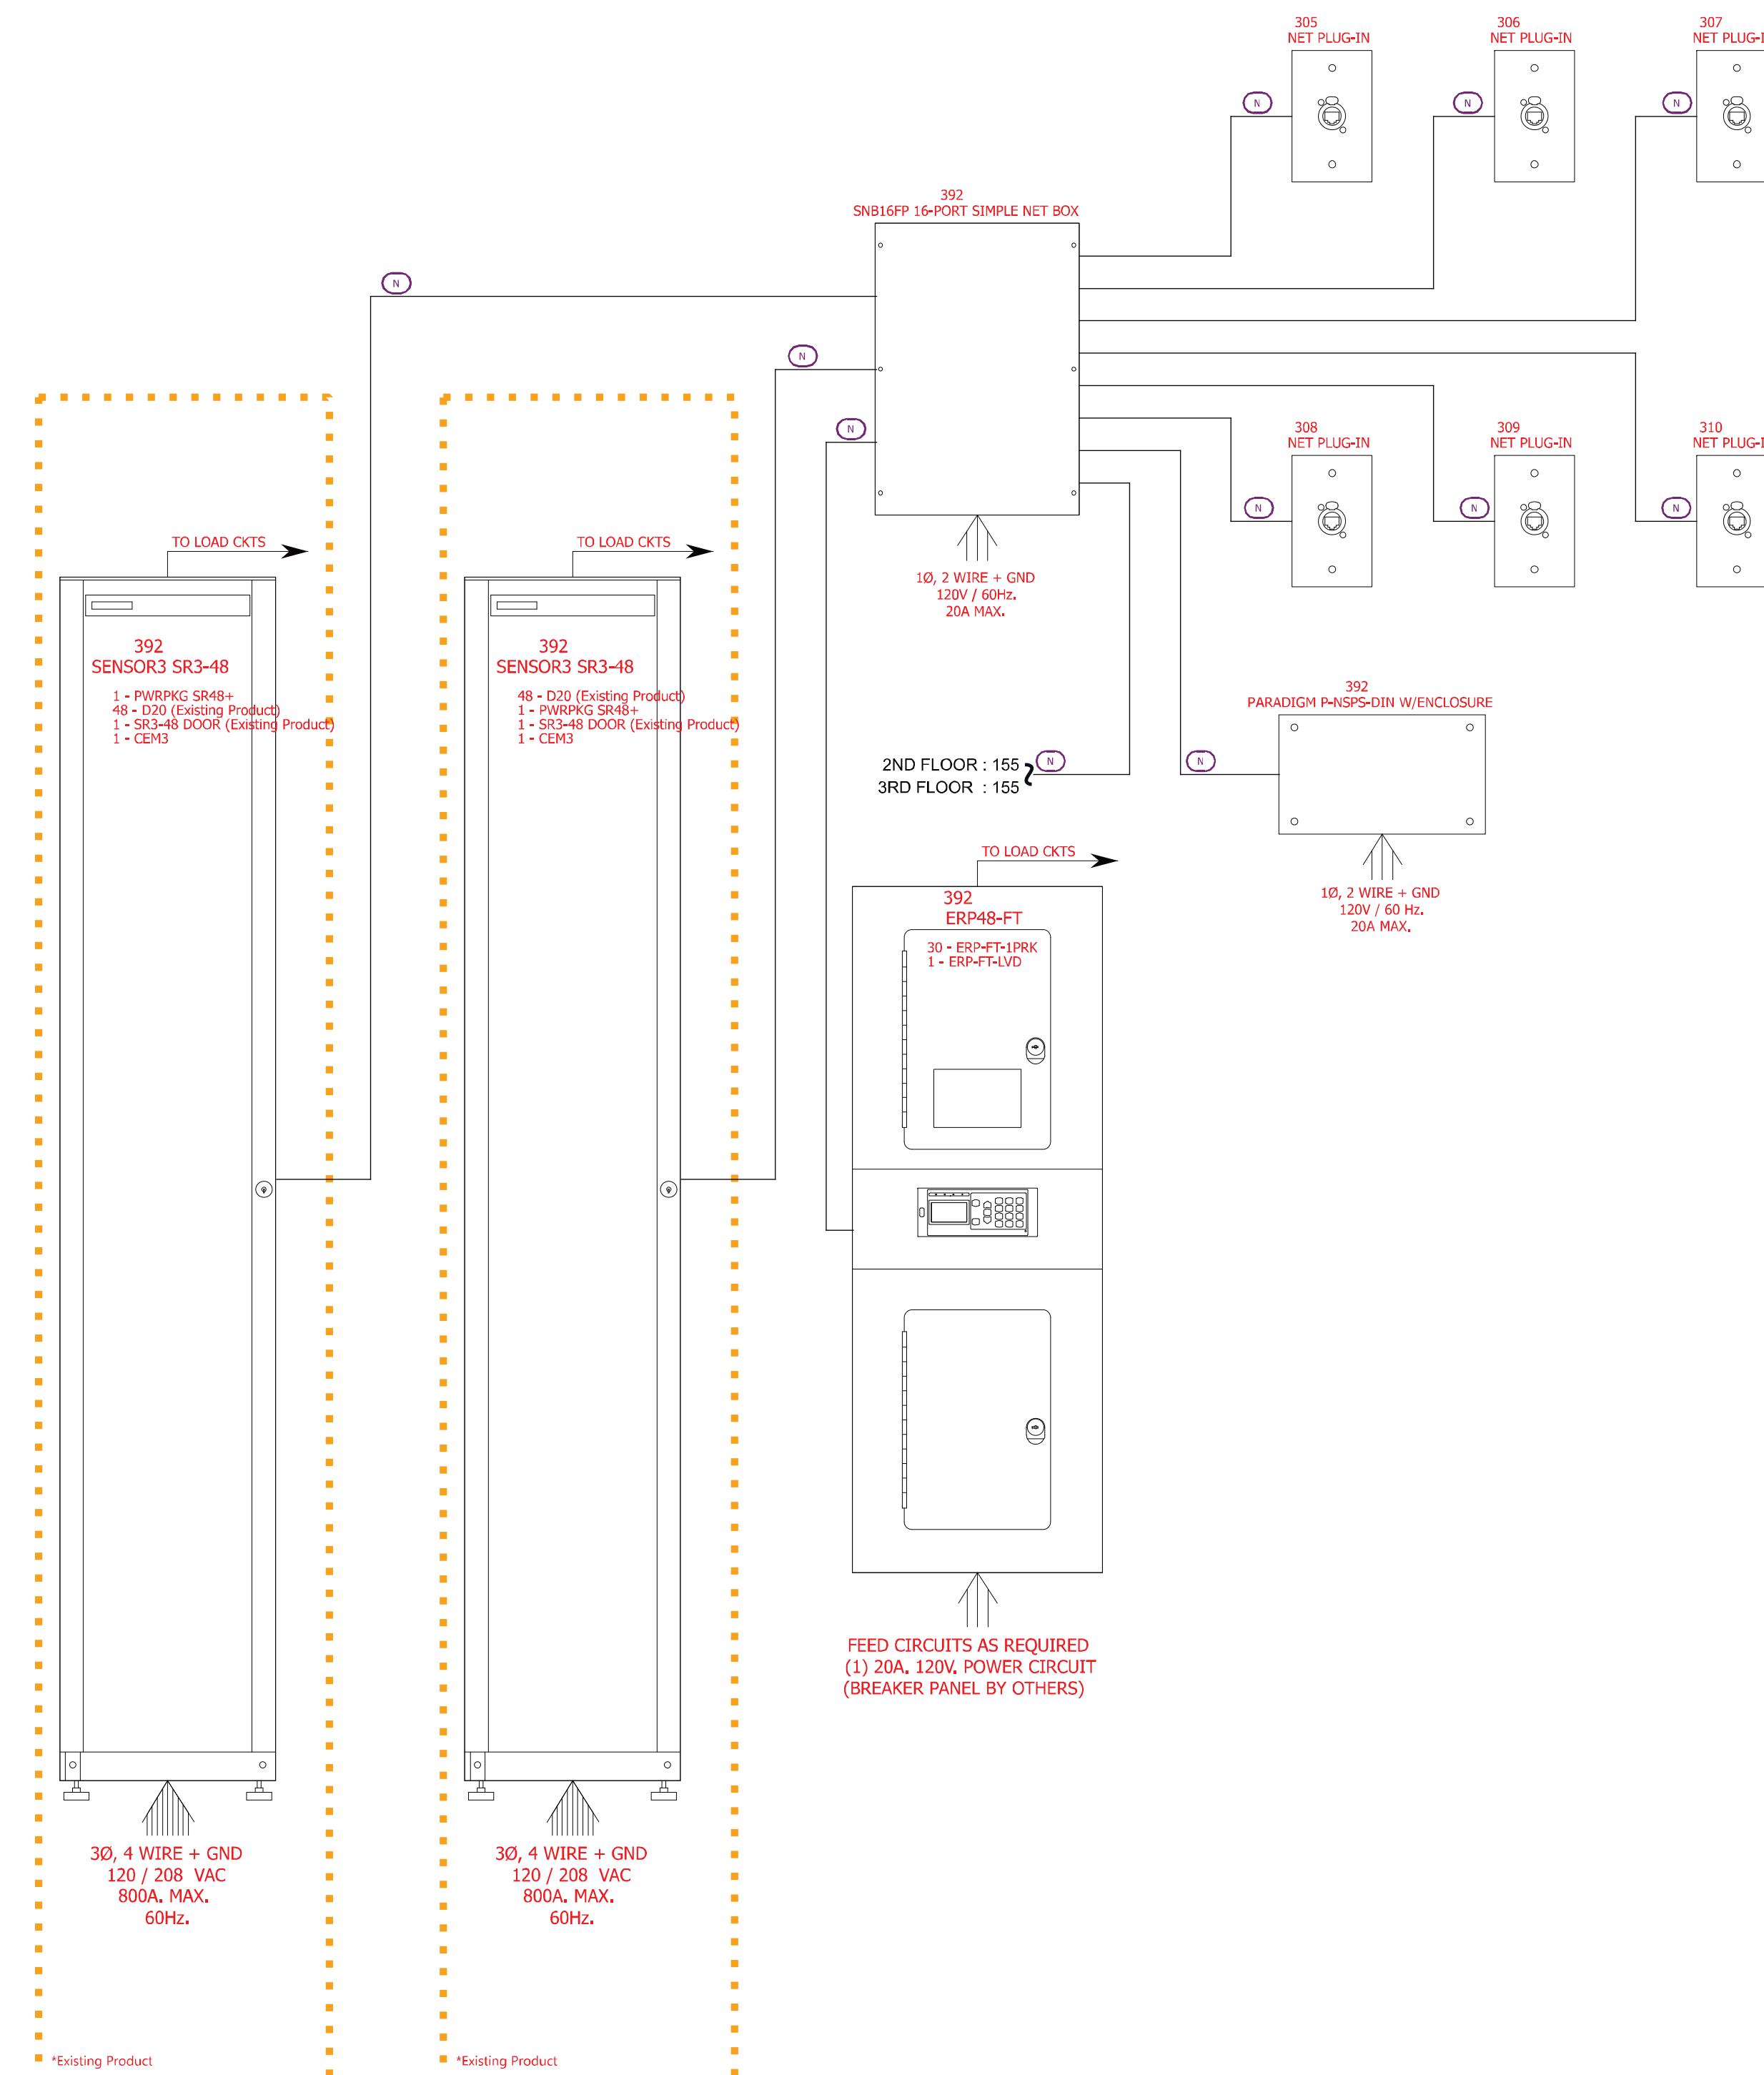

ETC, Inc.

3031 Pleasant View Rd.
PO Box 620979
Middleton WI 53562-0979
Toll Free + 1 800 688 4116
etcconnect.com

REPRESENTATIVE:



CLI

REFERENCE DRAWING:

PREPARED FOR:

PREPARED BY:

PROJECT MANAGER:

| | | |
|-----|---------|----|
| sam | 2/12/26 | #2 |
| rjd | 1/21/26 | #1 |
| | | |
| | | |
| | | |
| | | |
| | 2/6/25 | |

BY DATE
PROJECT NAME:
IU CAMPUS CENTER
UPGRADES

PROJECT LOCATION:
**INDIANAPOLIS , Indiana, USA,
46203**

PROJECT NUMBER: -

SHEET TITLE:

SHEET NUMBER:
4 of 6



Control wiring legend

| Symbol | Wire type(s) | Signal |
|--------|------------------------------|-------------|
| U | (1) TMB PCLP1PT (NON-PLENUM) | LINKCONNECT |
| A | (2) #16 AWG.STRANDED WIRES | AUXILIARY |
| PW | (3) #12 AWG. SOLID WIRE | POWER |
| CC | (2) #16 AWG.STRANDED WIRES | Contact |
| N | (1) BELDEN 1583A | NETWORK |


NOTE:
MODULES MAY BE DIFFERENT THAN D20
EXISTING UHCI TO BE J-BOX FOR "U" CABLE

Approved Wire Type Alternates can be found here:

<https://www.etcconnect.com/cablecross>

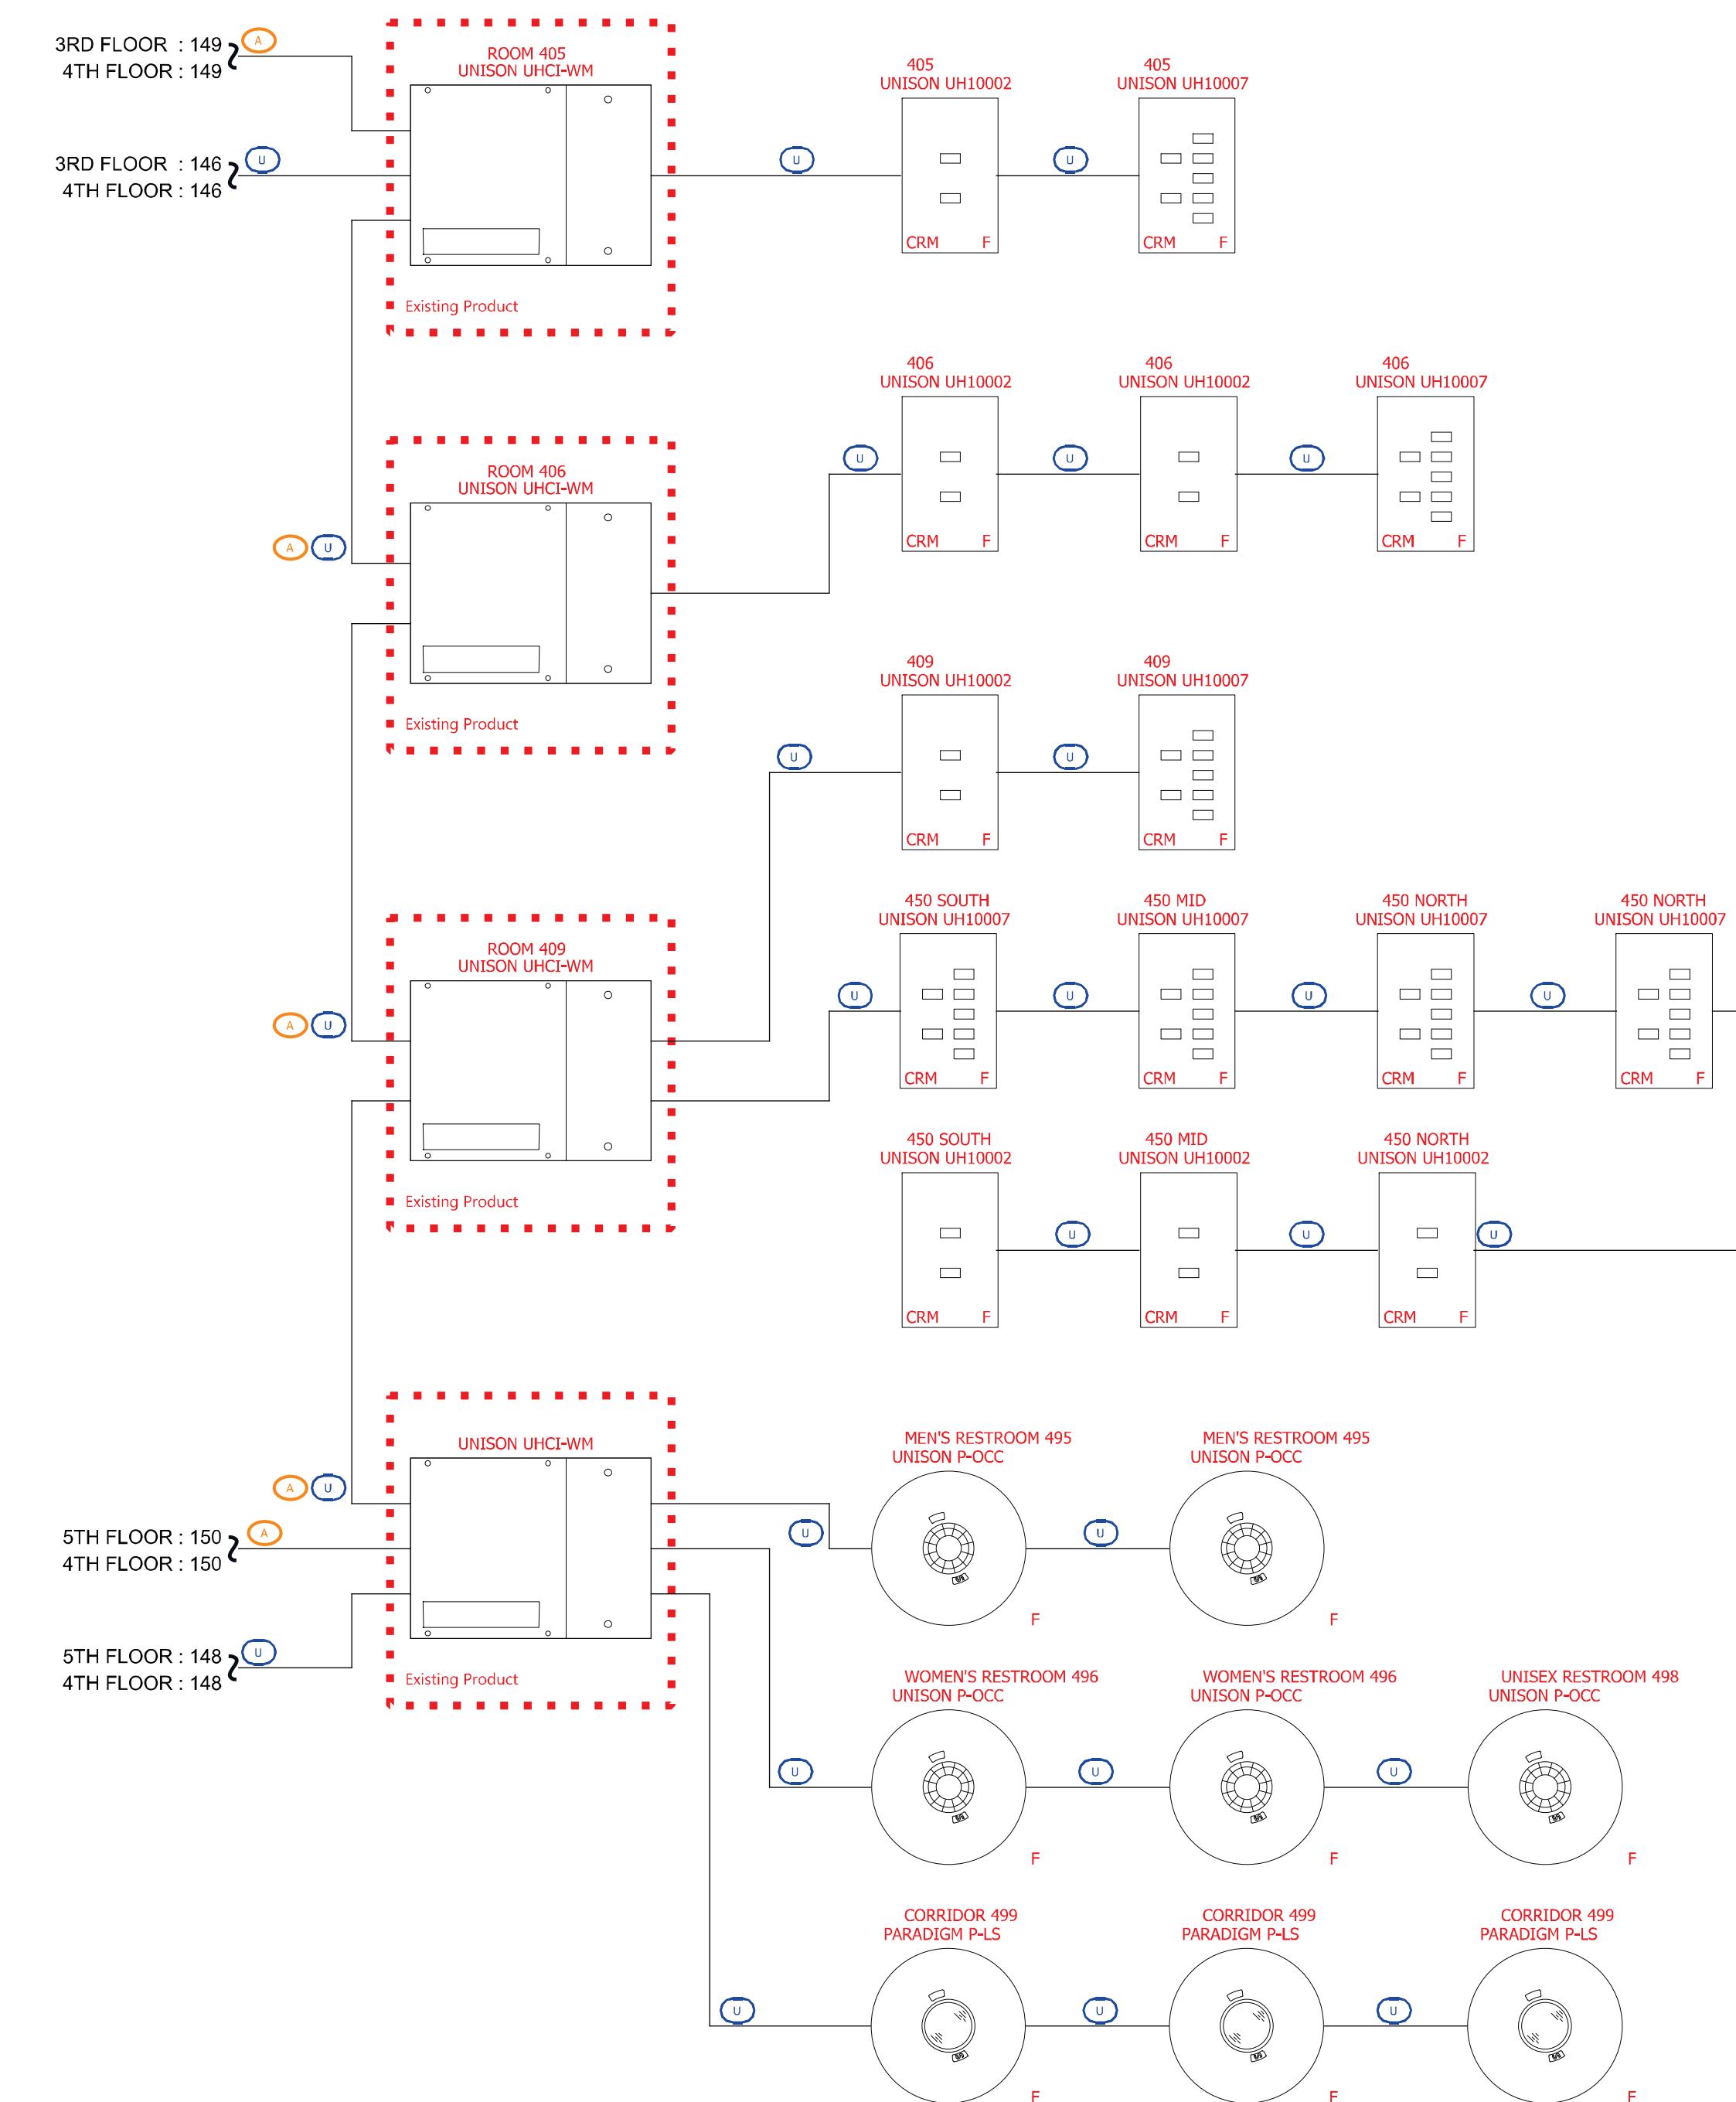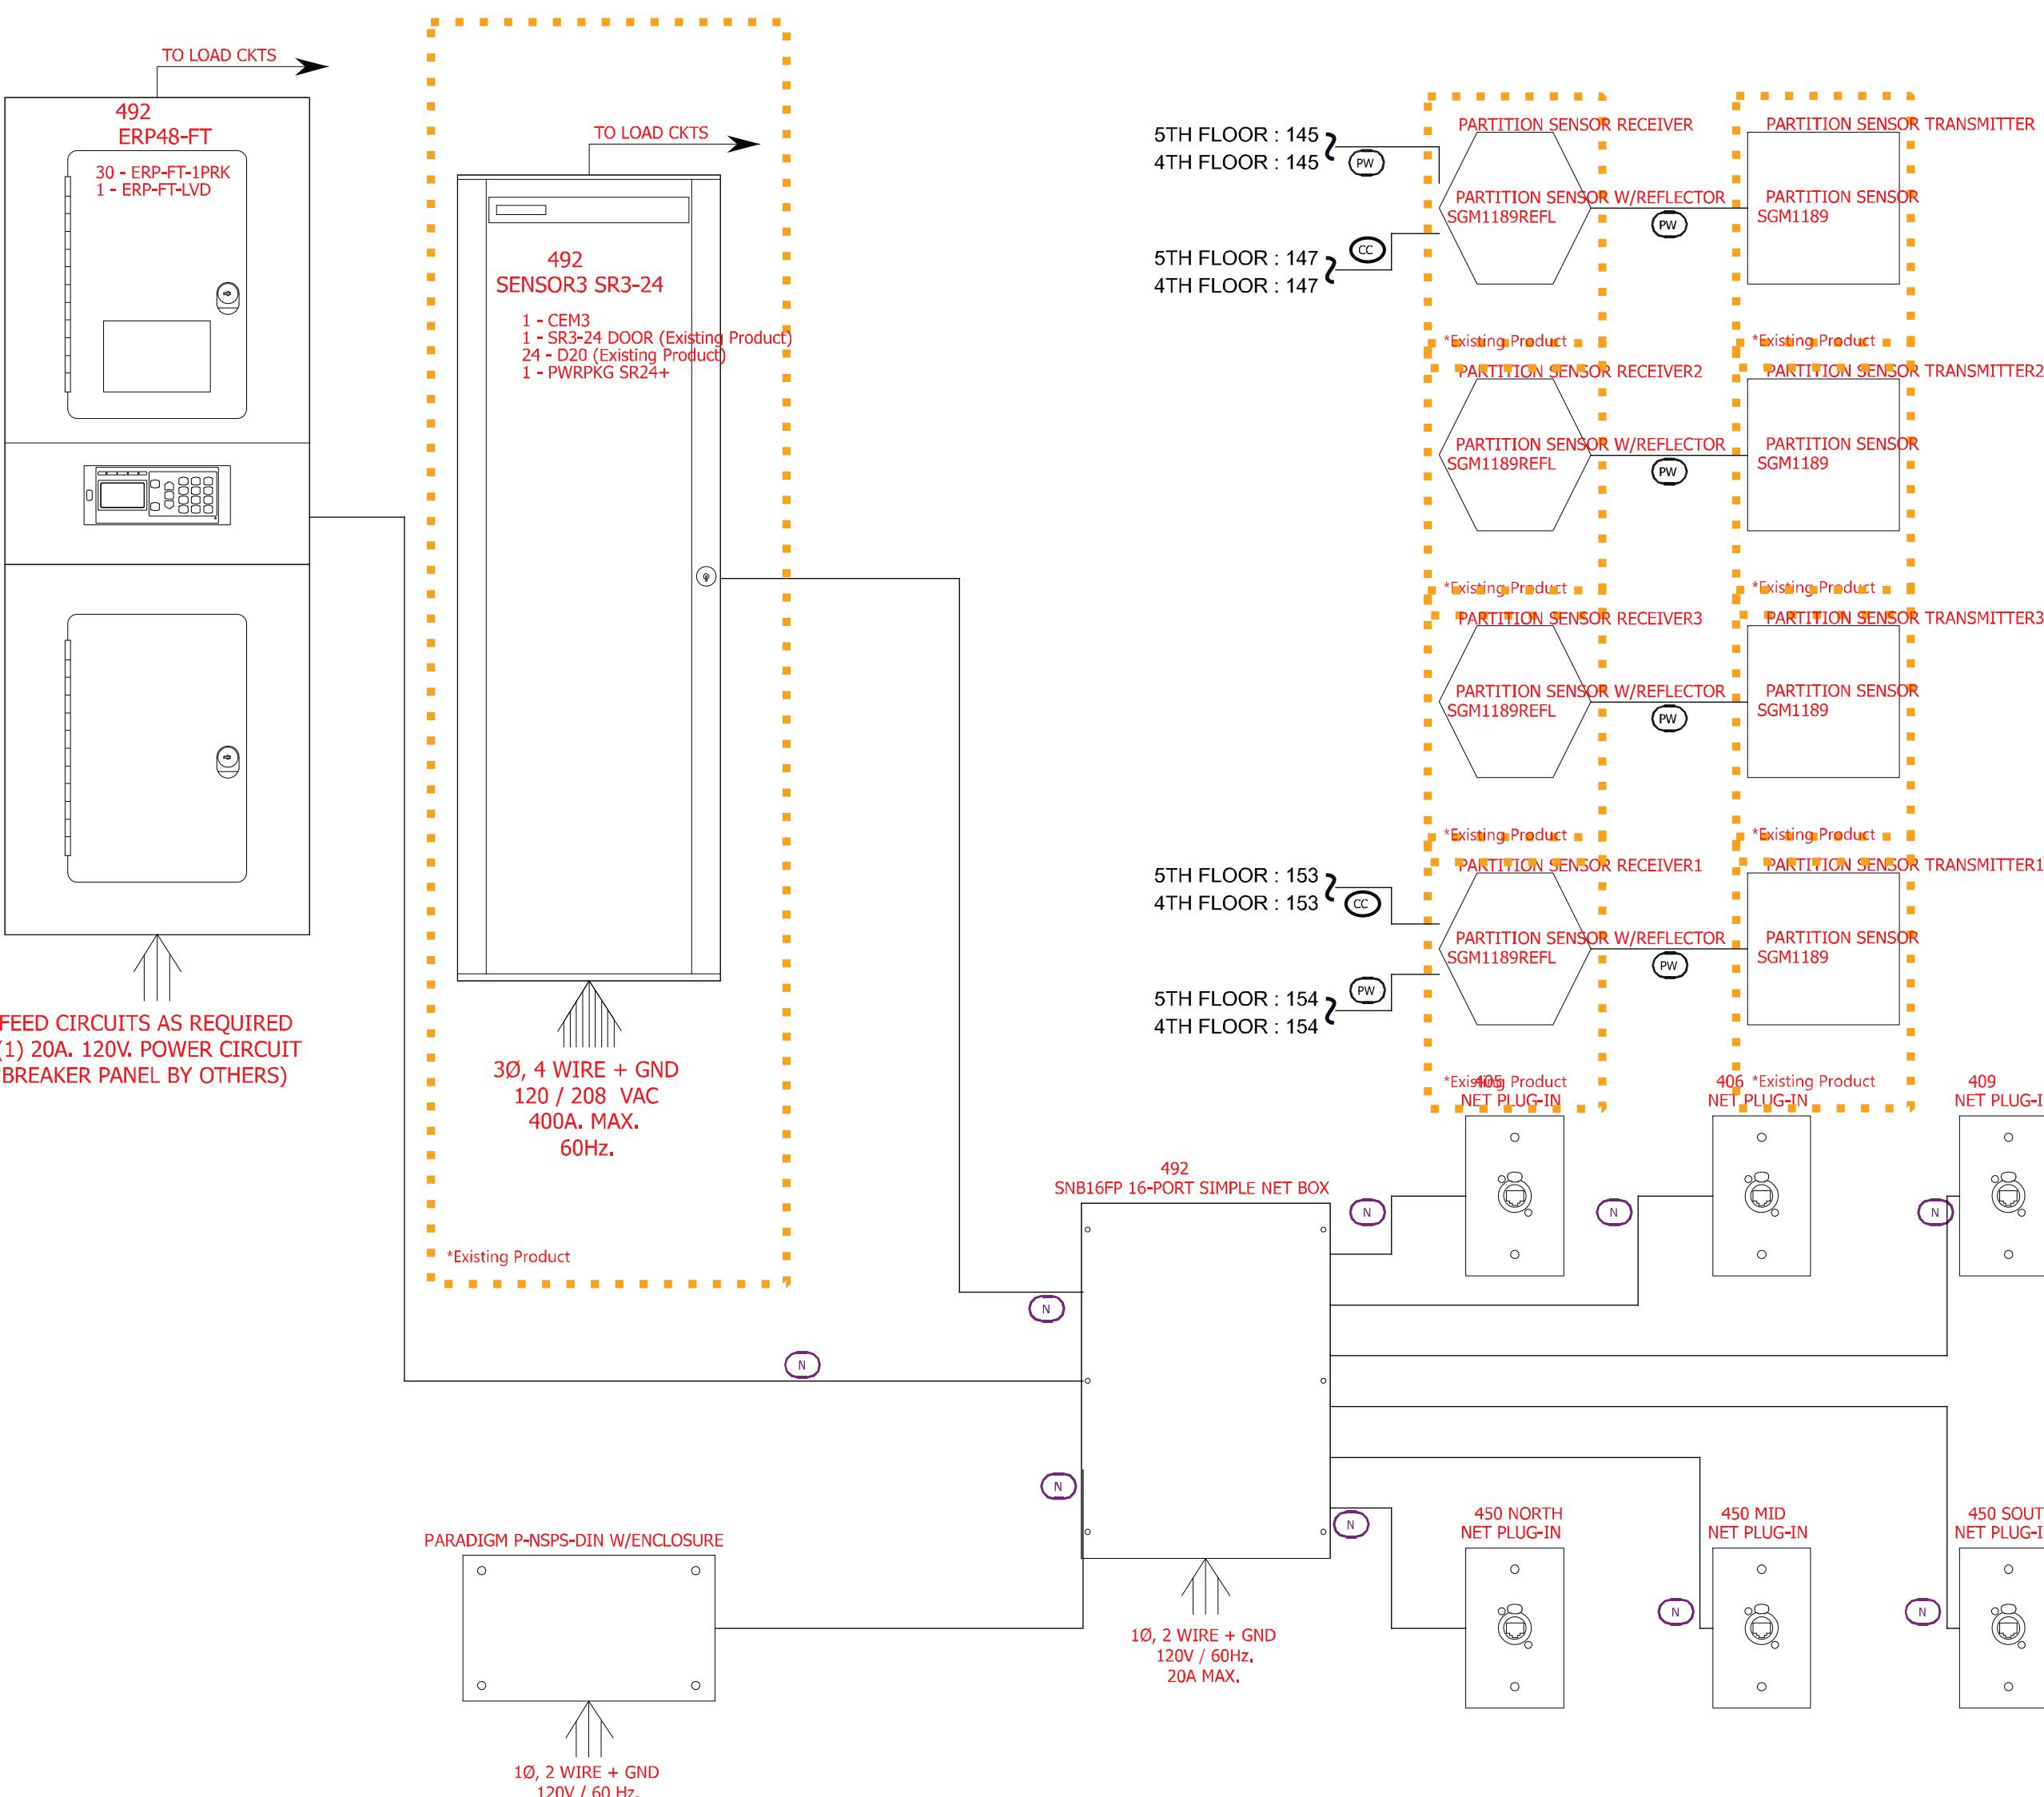

Area: 4TH FLOOR

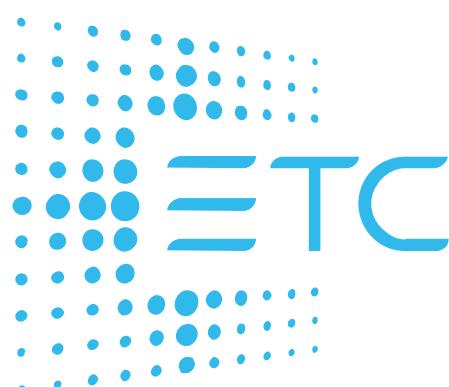

ETC, Inc.

3031 Pleasant View Rd.
PO Box 620979
Middleton WI 53562-0979
Toll Free + 1 800 688 4116
etcconnect.com

REPRESENTATIVE:



CLI

REFERENCE DRAWING:

PREPARED FOR:

PREPARED BY:

PROJECT MANAGER:

| | | |
|-----|---------|------|
| sam | 2/12/26 | #2 |
| rjd | 1/21/26 | #1 |
| | | |
| | | |
| | 2/6/25 | |
| BY | DATE | REV. |

PROJECT NAME:

IU CAMPUS CENTER
UPGRADES

PROJECT LOCATION:
INDIANAPOLIS, Indiana, USA,
46202

PROJECT NUMBER:


SHEET TITLE:
Fourth Floor

SHEET NUMBER:
5 of 6

Control wiring legend

| Symbol | Wire type(s) | Signal |
|--------|------------------------------|-------------|
| U | (1) TMB PCLP1PT (NON-PLENUM) | LINKCONNECT |
| A | (2) #16 AWG.STRANDED WIRES | AUXILIARY |
| CC | (2) #16 AWG.STRANDED WIRES | Contact |
| N | (1) BELDEN 1583A | NETWORK |
| PW | (3) #12 AWG. SOLID WIRE | POWER |

Approved Wire Type Alternates can be found here:
<https://www.etcconnect.com/cablecross>

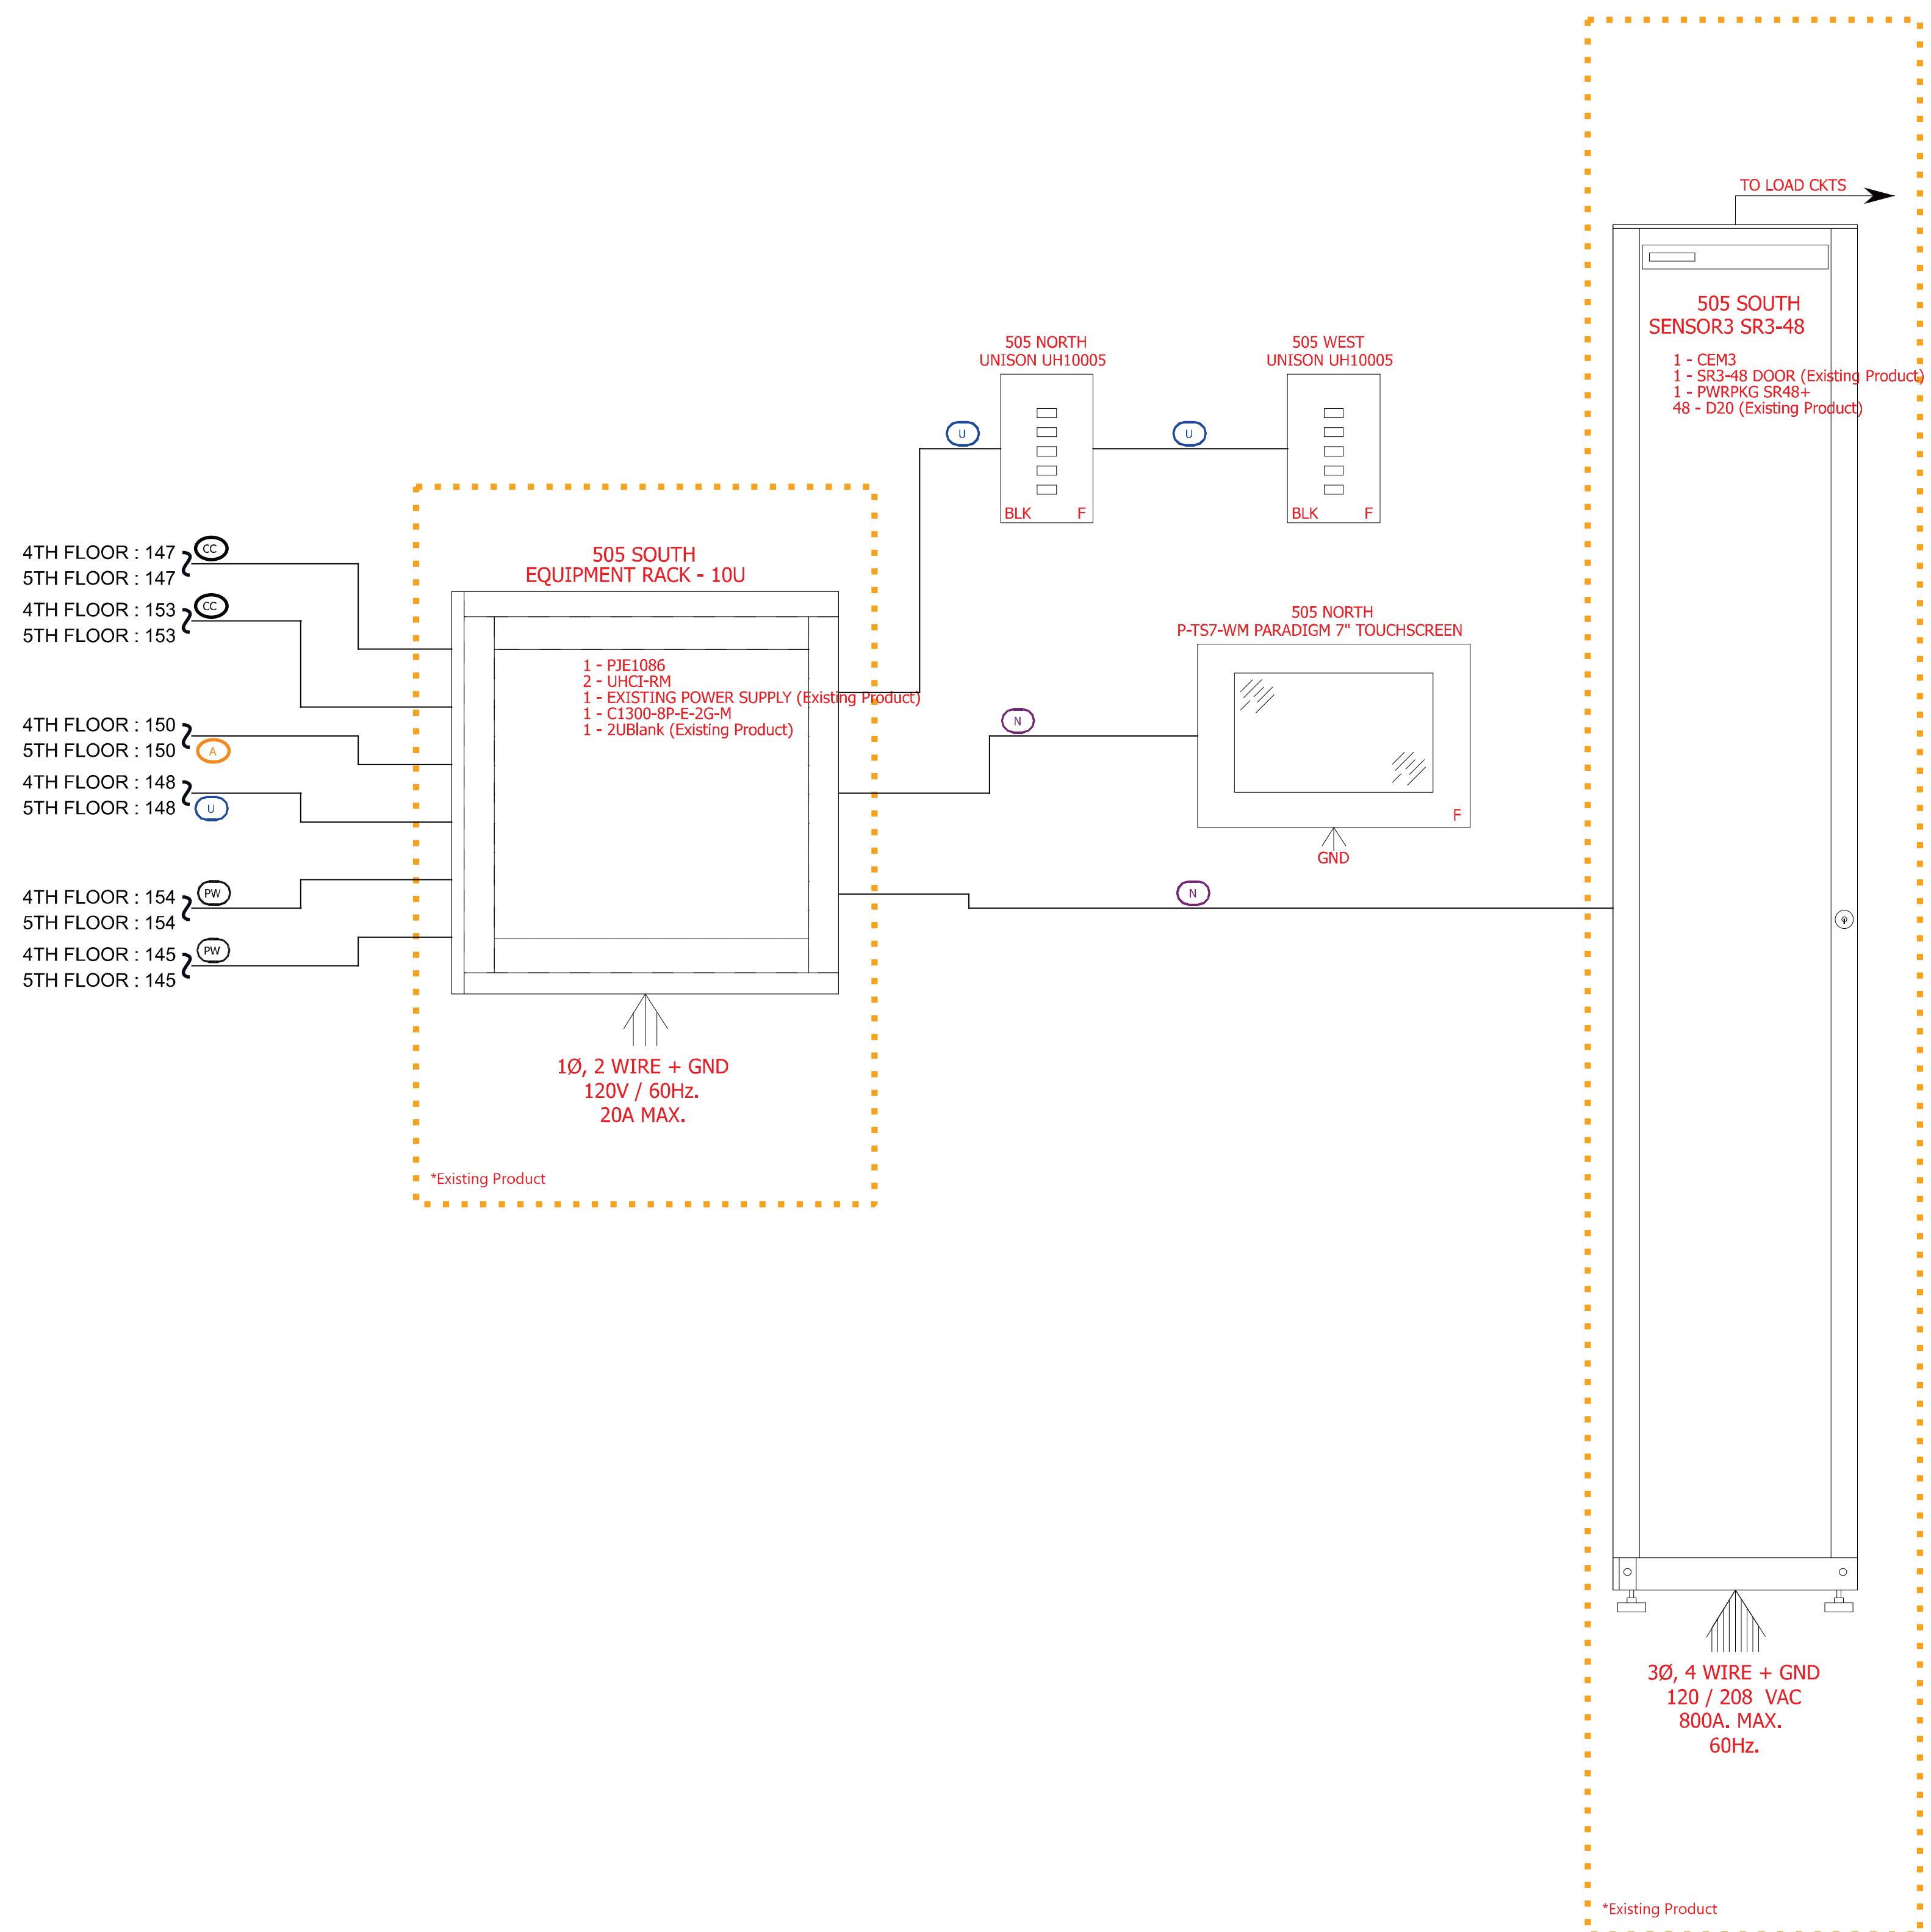

ETC, Inc.

3031 Pleasant View Rd.
PO Box 620979
Middleton WI 53562-0979
Toll Free + 1 800 688 4116
etcconnect.com

REPRESENTATIVE:



CLI

REFERENCE DRAWING:

PREPARED FOR:

PREPARED BY:

PROJECT MANAGER:

| | | |
|-----|---------|------|
| sam | 2/12/26 | #2 |
| rjd | 1/21/26 | #1 |
| | | |
| | | |
| | 2/6/25 | |
| BY | DATE | REV. |

PROJECT NAME:

IU CAMPUS CENTER
UPGRADES

PROJECT LOCATION:
INDIANAPOLIS, Indiana, USA,
46202

PROJECT NUMBER:

SHEET TITLE:
Fifth Floor

SHEET NUMBER:
6 of 6